



MONTGOMERY COUNTY EXECUTIVE ORDER

Offices of the County Executive • 101 Monroe Street • Rockville, Maryland 20850

| | | |
|---|----------------------------------|-----------------------------|
| Subject Fire Lane Establishment Order for Northgate Community Church | Executive Order No. 142-15 | Subject Suffix |
| Originating Department Montgomery County Fire and Rescue Service | Department Number MCFRS 20-15 | Effective Date 9/22/2015 |

Fire Lane Establishment Order

Pursuant to Section 22 - 33, Montgomery County Code, 1971, as amended, you are hereby notified that a Fire Lane has been established as described in this order. You are hereby ordered to post fire lane signs and paint curbs/pavement (painting optional) as identified below. When signs and paint work (painting optional) have been completed, this order will authorize the enforcement of this Fire Lane by appropriate police and fire officials. Compliance with this order must be achieved within 30 days of receipt.

LOCATION: 20300 Pleasant Ridge Rd.

All areas where indicated by signs and paint.

- SIGNS - - (See attached diagram for location of sign placement)



\$250 FINE

FIRE LANE



Signs must be posted so that it is not possible to park a vehicle without being in sight of a sign. Signs may be no further apart than 100 feet

(Red letters on white background)

- PAINT - - (See attached diagram if painting).


Paint must be traffic yellow with lines of sufficient width to be readily identifiable/readable by motor vehicle operators.

Scott Coe
Fire Chief, Montgomery County Fire and Rescue Service

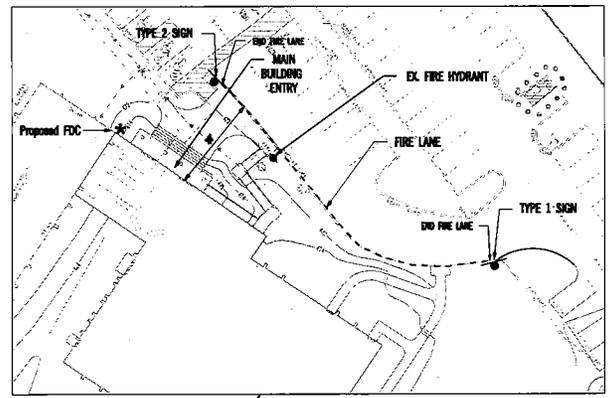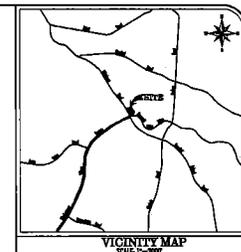

ENLARGEMENT OF FIRE LANE AREA
1" = 20'



PROPOSED FIRE LANE SIGNS

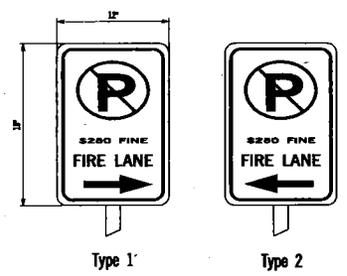

Sign type locations indicated on drawing

Note:
Proposed signs to be placed on steel channel posts with bottom of sign at 7 feet above adjacent sidewalk surface. Post to be installed at back of curb within expansion joint.

Signs to be red lettering on white background.

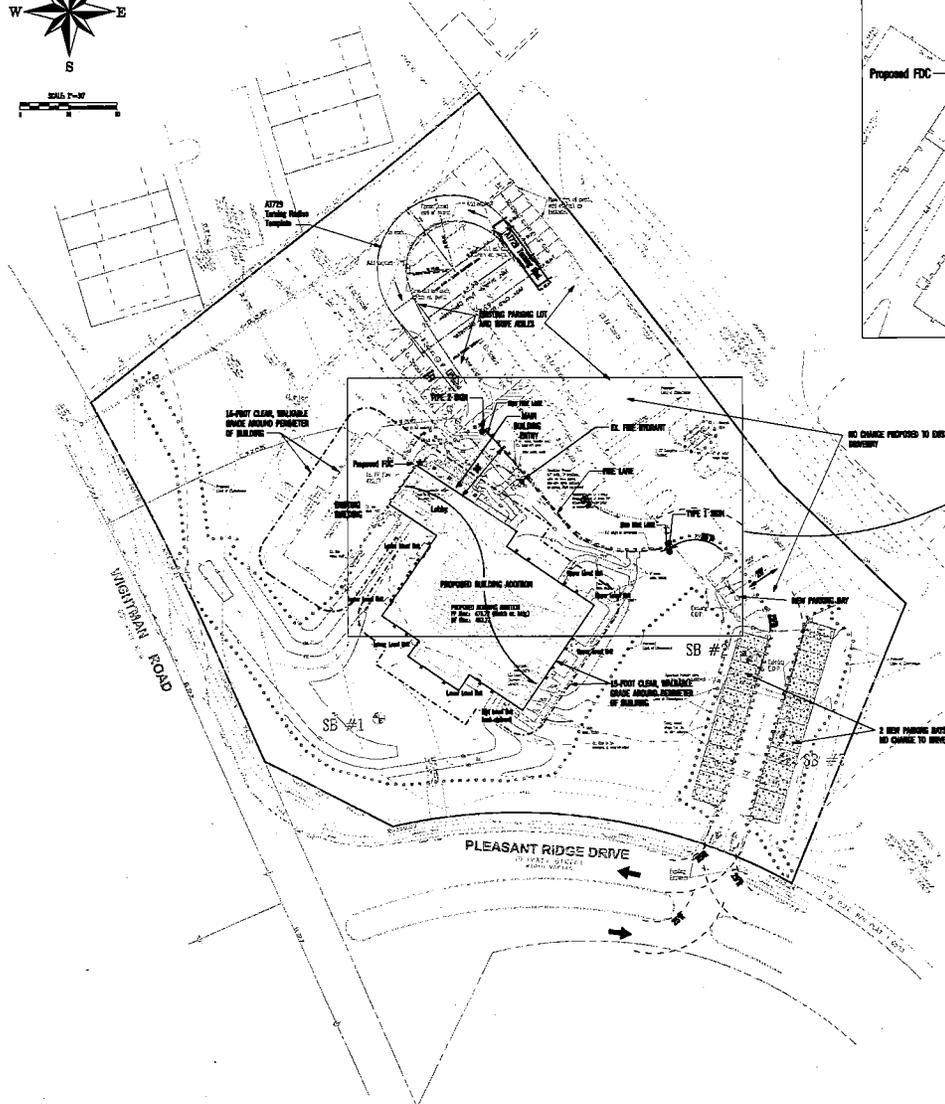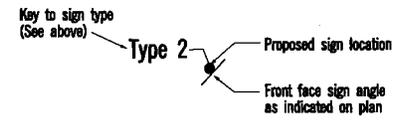

SSI SITE SOLUTIONS, INC.
20210 Observance Drive, Suite 200
Rockville, Maryland 20850-4000
(301) 460-7800 Fax (301) 460-7801
Planning, Site Design, Architecture
Engineering, Surveying

| | | |
|----|----------|------|
| NO | REVISION | DATE |
| | | |
| | | |
| | | |

OWNER:
Northgate Community Church, Inc.
20300 Pleasant Ridge Drive
Montgomery Village, Md. 20886
Pastor Daniel Switzer

Professional Certification: I hereby certify that these drawings were prepared or approved by me, and that I am a duly Licensed Professional Engineer under the laws of the State of Maryland, License No. 7759, Expiration 12/31/2017.



EMERGENCY ACCESS PLAN
NORTHGATE COMMUNITY CHURCH ADDITION
Parcel 8, Essex Place, Montgomery Village
20300 PLEASANT RIDGE DRIVE
LANTONVILLE ELECTION DISTRICT #1
MONTGOMERY COUNTY, MARYLAND

| | | |
|-----------|-----------|----------|
| DRAWN | SCALE | 1" = 30' |
| REVISION | SCALE | 1" = 1' |
| CHECKED | DATE | 11/19/14 |
| DATE PLOT | DATE PLOT | 11/19/14 |

DATE PLOTTED: 11/19/14 10:58 AM